

ELECTRICAL LEGEND

	CEILING FITTING
	WALL MOUNTED FITTING (INTERNAL)
	WALL MOUNTED FITTING (EXTERNAL)
	WALL MOUNTED FITTING (EXTERNAL) ON DAY/NIGHT SWITCH
	LOW POSITION WALL MOUNTED FITTING (EXTERNAL)
	DROP LIGHT FITTING
	BRAM LIGHT
	DOUBLE TUBE FLUORESCENT
	SINGLE 15AMP PLUG
	DOUBLE 15AMP PLUG
	WATERPROOF SINGLE 15AMP PLUG (EXTERNAL)
	CEILING MOUNTED 15AMP PLUG
	SHAVER PLUG
	LIGHT SWITCH
	2/3/4-WAY LIGHT SWITCH
	DOOR BELL SWITCH
	DIMMER
	SATELLITE TELEVISION POINT
	TELEPHONE POINT
	COOKERHOOD EXTRACTOR UNIT
	DISTRIBUTION BOARD
	METER BOARD
	GEYSER
	HEAT PUMP (CONNECTED TO GEYSER)
	ELECTRICAL WIRING

AREA'S

Dwelling: 430.7sqm
 Carport : 115sqm
 Total area covered : 545.7sqm

Erf : 1738.6sqm

% built : 31.4%



M. Young
 Prof. Arch. Dr. (PAD 20757)
 B.Tech Civil Eng.
 2 Tugela Cl.
 Kraalbosch
 George
 6546
 e-mail : mycad3@gmail.com
 Cell. 082 4219184

OWNER :

Mr. G. de Bruyn
 5th AVE
 Erf 777
 Wildernis

PROJECT :


Proposed new dwelling

DRAWING :


Floor plans, Section,
 Electrical layout

SCALE	DATE	DRAWN	NO
1 : 100	22/08/2022	M. Y.	2/4


ALL MEASUREMENTS TO BE CHECKED ON SITE
 COPYRIGHT RESERVED

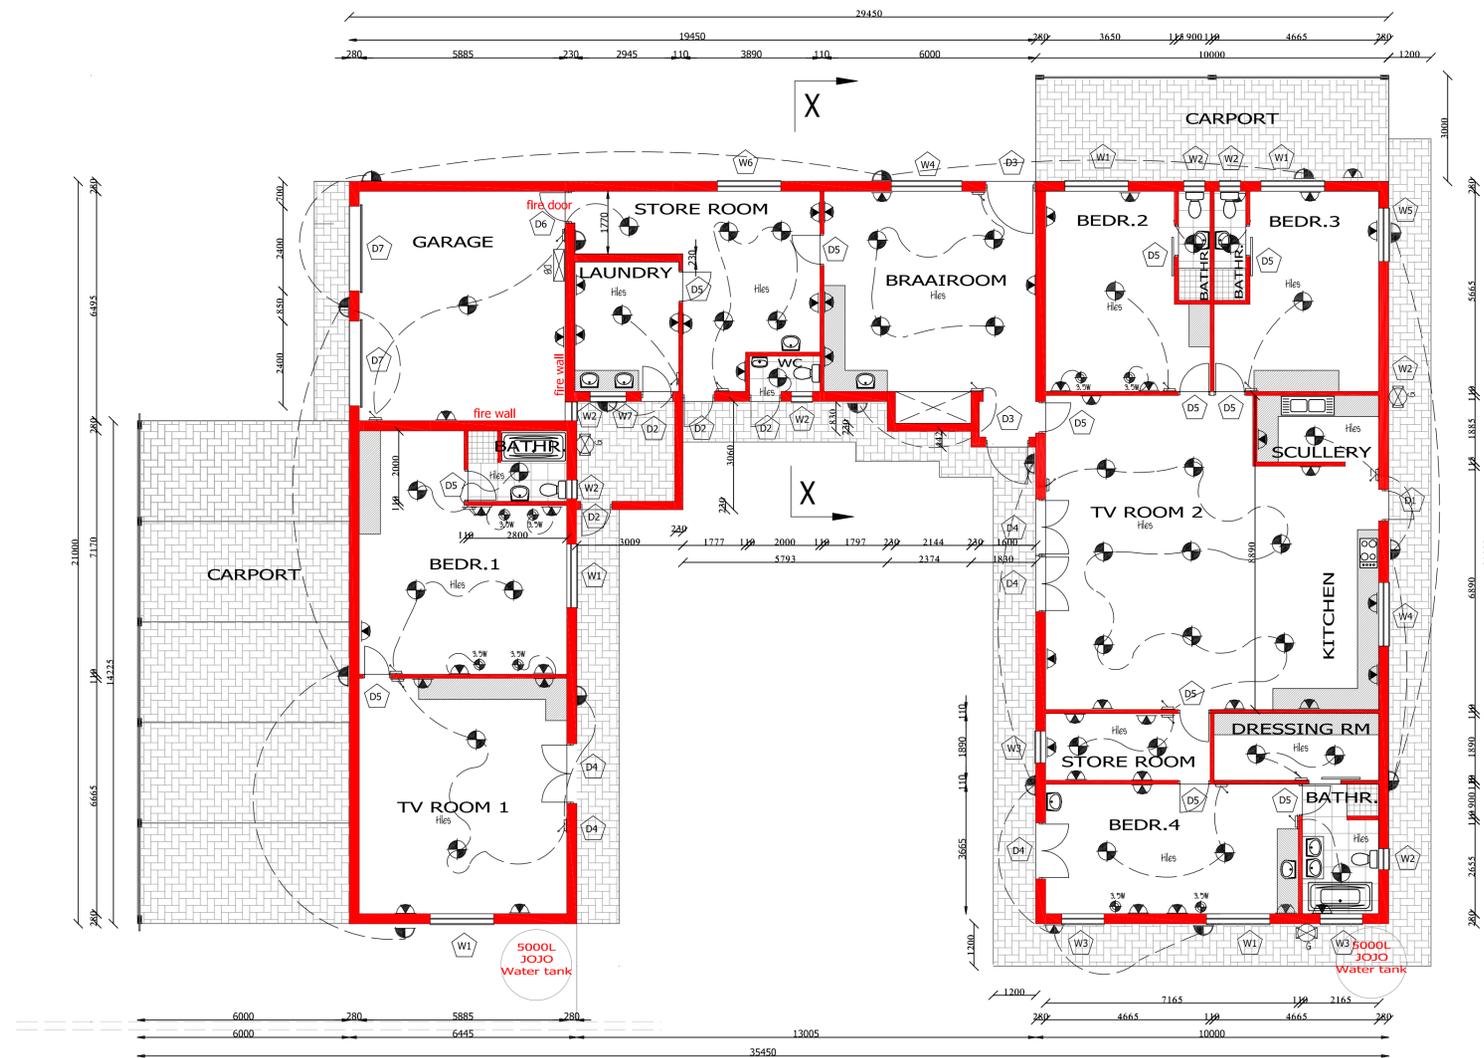

FLOOR PLAN
 scale 1:100

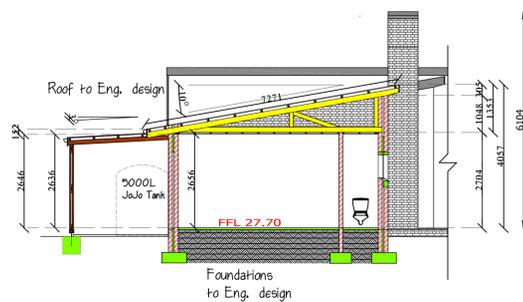

SECTION X-X
 scale 1:100

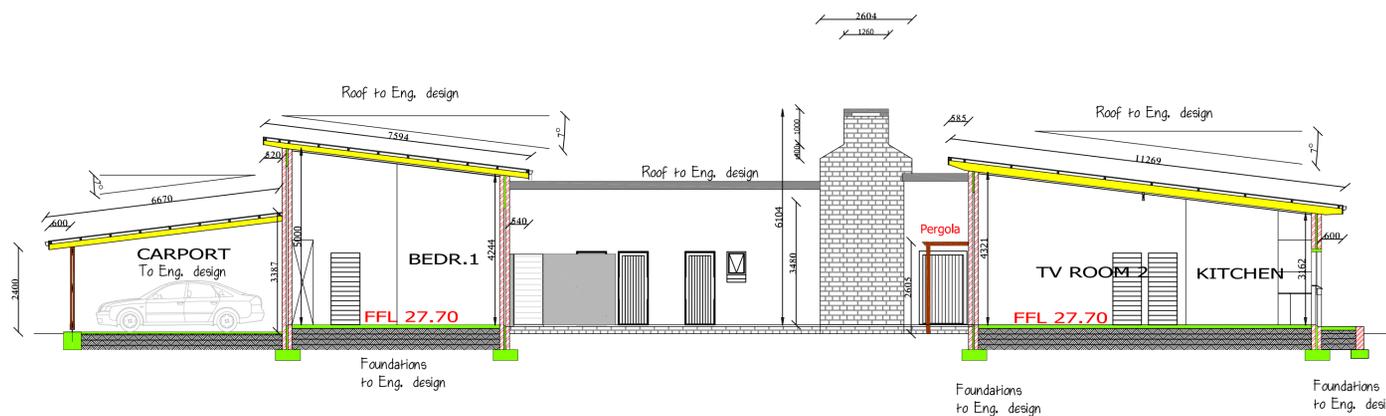

SECTION Y - Y
 scale 1:100